


SPRINKLER RISER

NOT TO SCALE

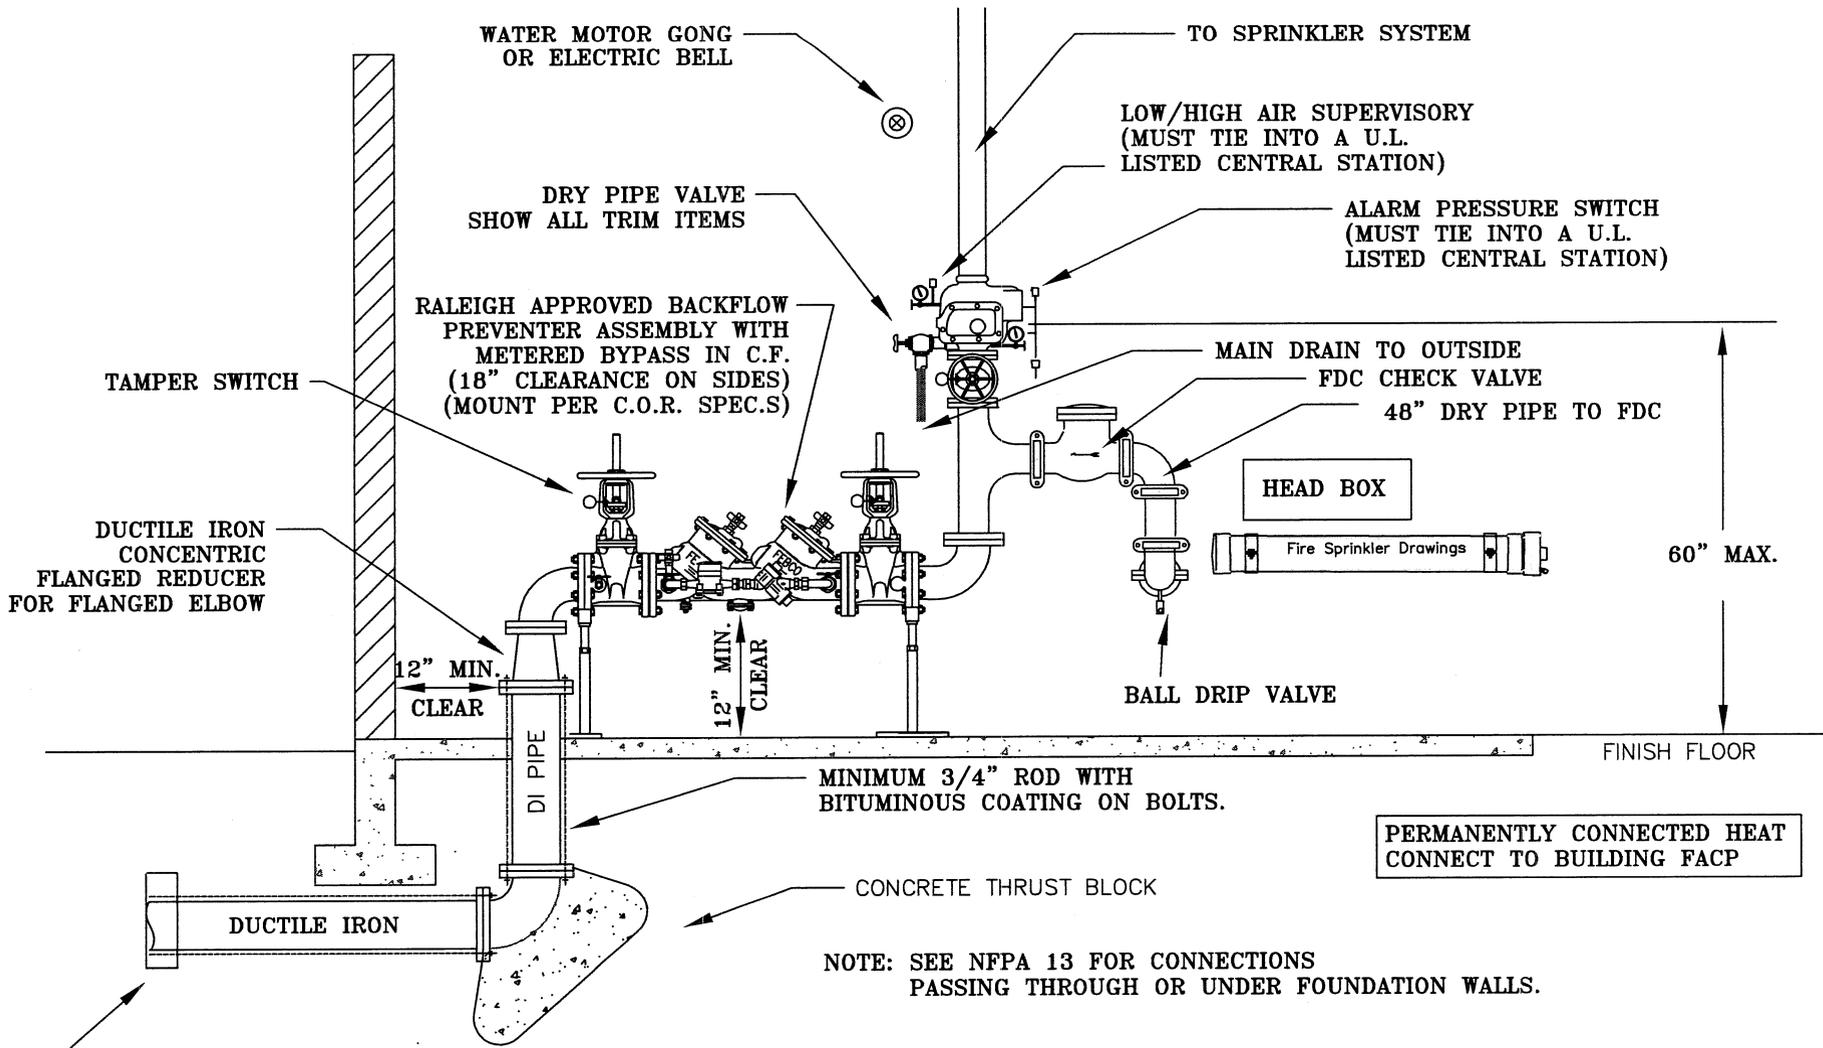

SPRINKLER RISER

NOT TO SCALE

CITY OF RALEIGH FIRE DEPARTMENT
 FIRE PROTECTION DIVISION
 310 WEST MARTIN ST. RALEIGH, NC 27602

DESCRIPTION:
 SPRINKLER RISER DETAIL (DRY)

REVISIONS:
 5-1-06

DATE:

DRAWING NO.
 FP-4A